

LEGEND

W

SS

E

G

Proposed Water Pipe

Proposed Sanitary Pipe

Proposed Electric Wire


Proposed Gas Line

Proposed Water Meter

Proposed Water Valve

Proposed Electrical Service Point

Proposed Electrical Handhole

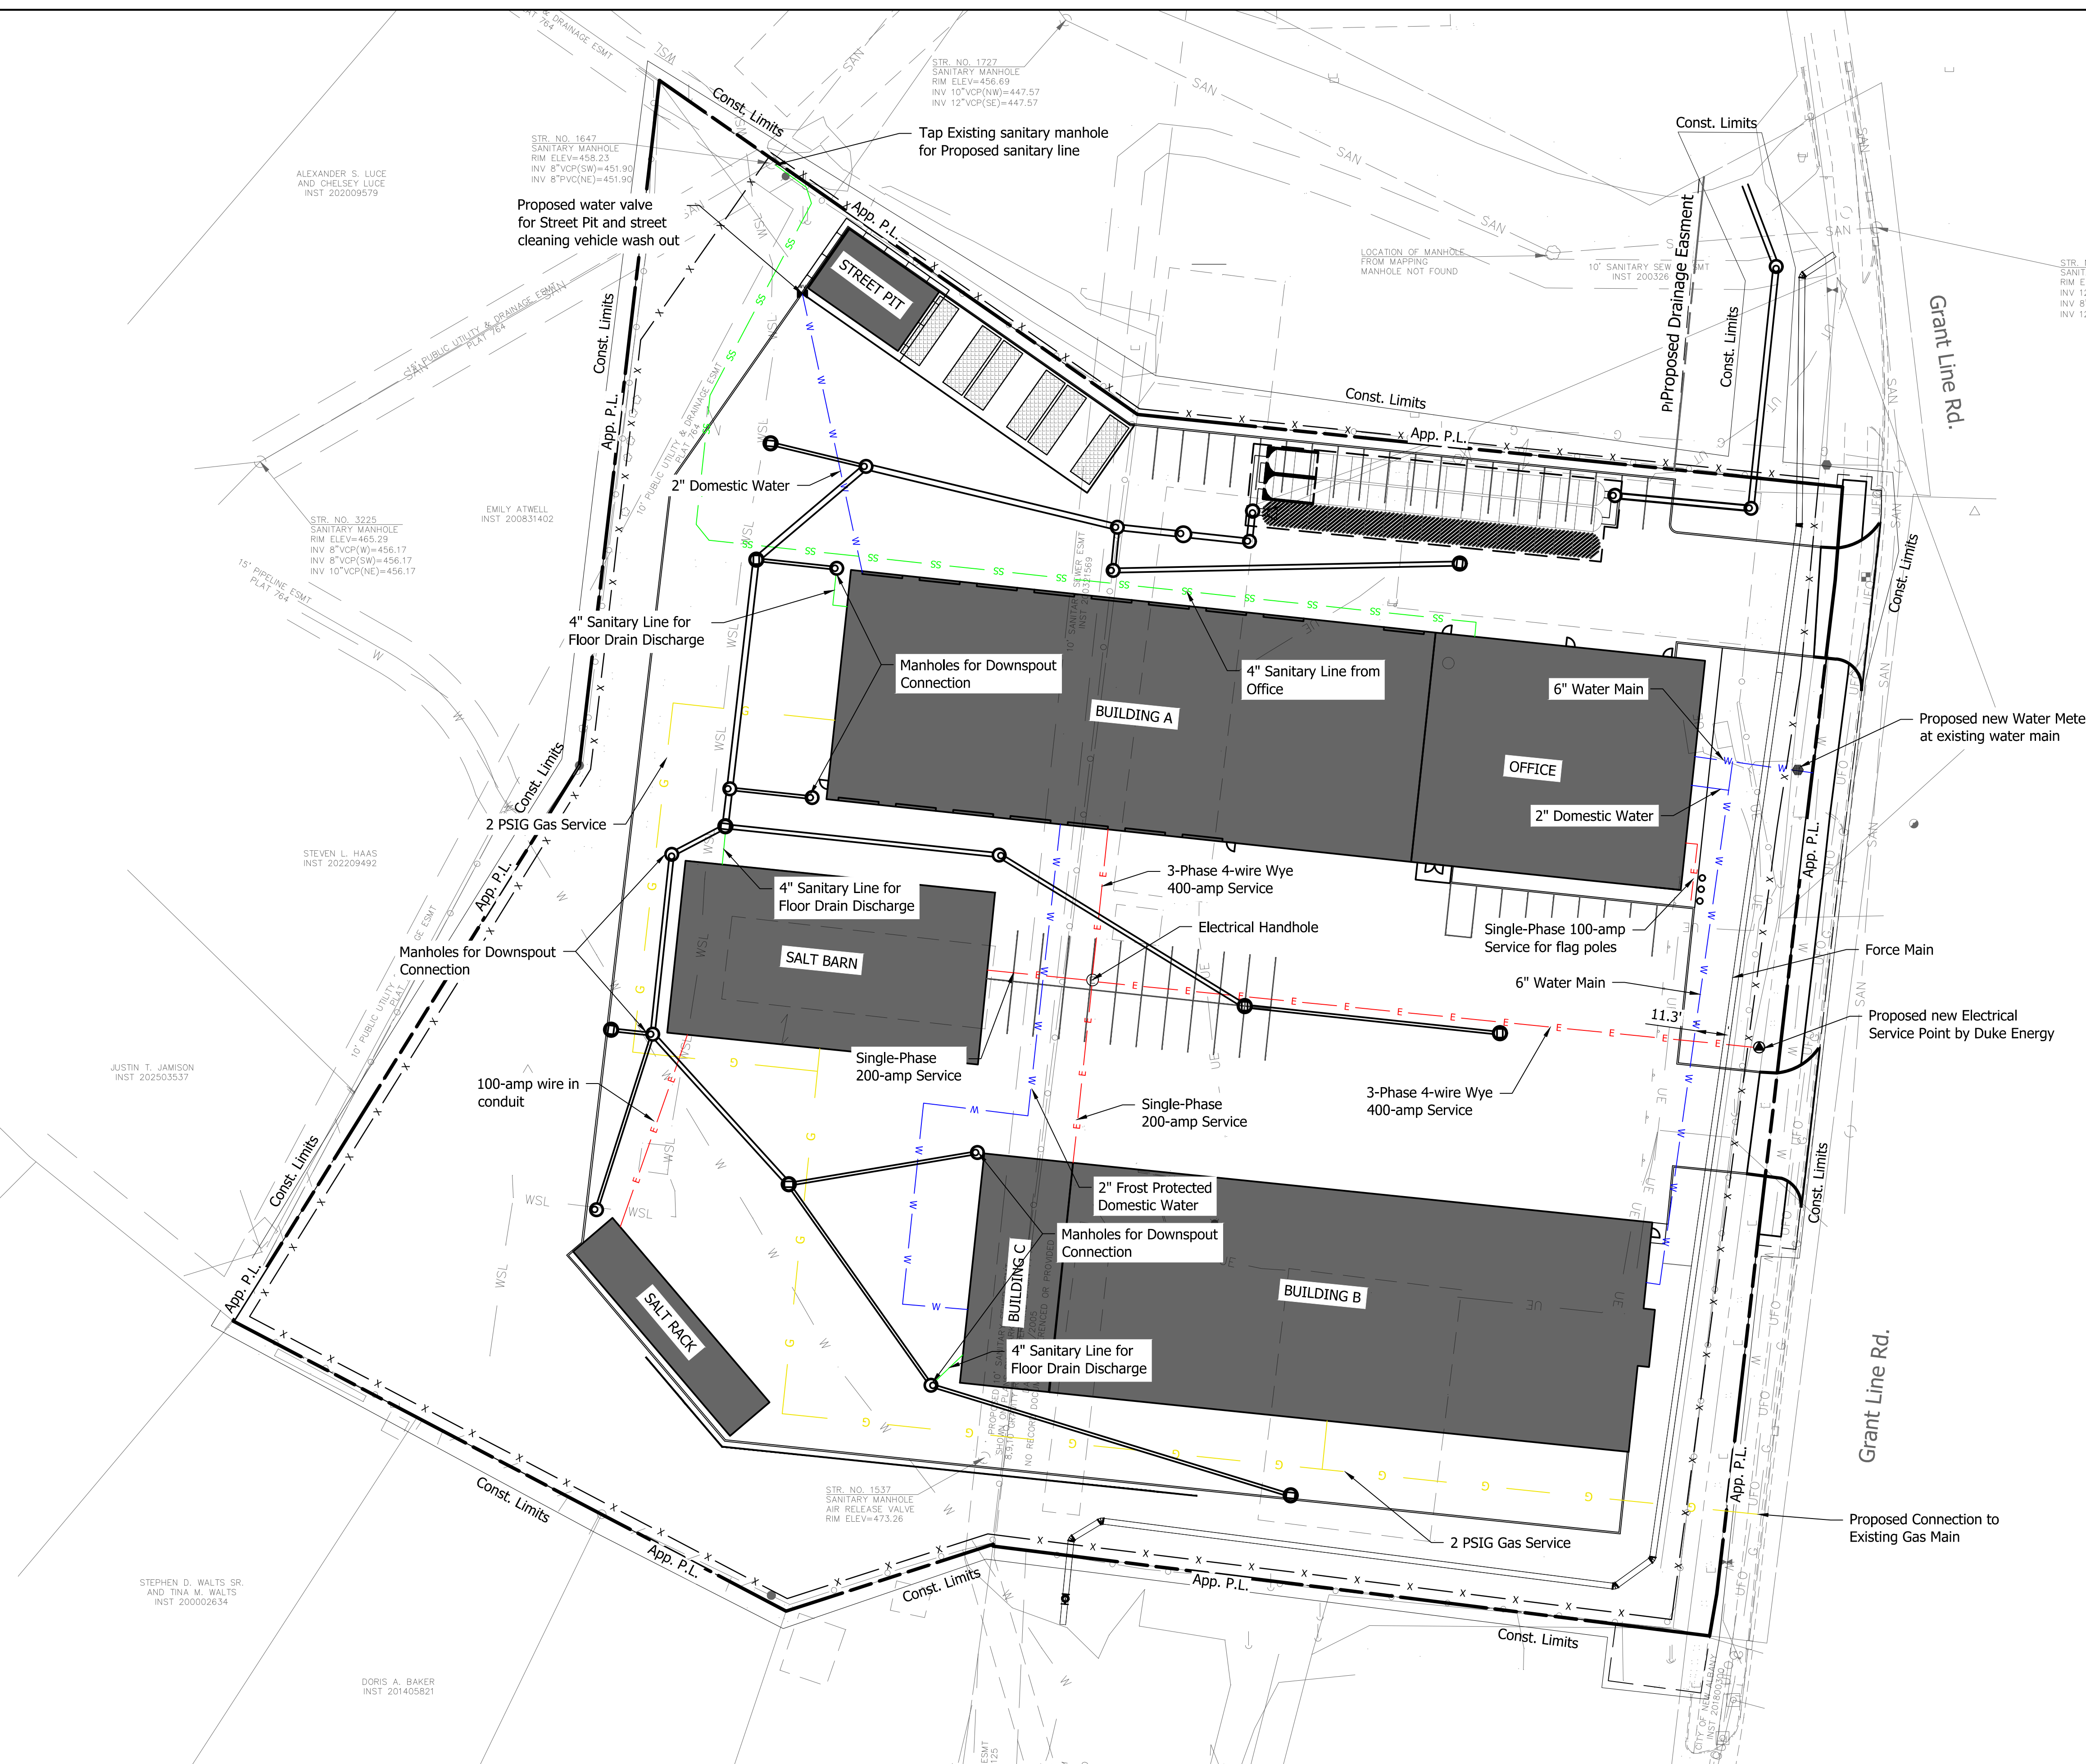

Notes:
1. Underground utilities are to be installed a minimum of 36" below Final Grade



8440 Allison Pointe Boulevard, Suite 200
Indianapolis, IN 46250
Phone 317-895-2585
www.ucindy.com

RECOMMENDED FOR APPROVAL	
DESIGNED: EHT	DRAWN: EHT
CHECKED: CCR	CHECKED: CCR

CITY OF
NEW ALBANY

UTILITY
SITE PLAN

HORIZONTAL SCALE	BRIDGE FILE
1" = 30'	-
VERTICAL SCALE	DESIGNATION
N/A	-
SHEETS	
7	of 17
CONTRACT	
-	